

VETERANS ADMINISTRATION MEDICAL CENTER, BUILDING 107  
Gulfport Division, Biloxi  
Gulfport  
Harrison County  
Mississippi

HABS No. MS-269- F

HABS  
MS-269-F

**PHOTOGRAPHS**

**WRITTEN HISTORICAL AND DESCRIPTIVE DATA**

Historic American Buildings Survey  
National Park Service  
Southeast Region  
Department of the Interior  
Atlanta, Georgia 30303

UNITED STATES DEPARTMENT OF THE INTERIOR  
NATIONAL PARK SERVICE


ARCHITECTURAL DATA FORM

STATE Mississippi	COUNTY Harrison	TOWN OR VICINITY Gulfport
HISTORIC NAME OF STRUCTURE (INCLUDE SOURCE FOR NAME) VETERANS ADMINISTRATION MEDICAL CENTER, BUILDING 107		HABS NO. MS-269-F
SECONDARY OR COMMON NAMES OF STRUCTURE		
COMPLETE ADDRESS (DESCRIBE LOCATION FOR RURAL SITES) VA Medical Center, Building 107, Gulfport Division Biloxi, MS 39531		
DATE OF CONSTRUCTION (INCLUDE SOURCE) 1917 Government Records	ARCHITECT(S) (INCLUDE SOURCE) Veterans Administration architects No specific employee	
SIGNIFICANCE (ARCHITECTURAL AND HISTORICAL, INCLUDE ORIGINAL USE OF STRUCTURE) Building 107 is a three bedroom, one bath, residential type wood frame building. The building was used as a farm manager's quarters. Later it was used as the Engineering Officers quarters. Then General staff quarters.		
STYLE (IF APPROPRIATE)		
MATERIAL OF CONSTRUCTION (INCLUDE STRUCTURAL SYSTEMS) Residential type wood frame building with wood floors with plaster or sheetrock interior walls and ceilings. Roof is wood decking with asphalt shingles.		
SITE AND DIMENSIONS OF STRUCTURE (SKETCHED FLOOR PLANS ON SEPARATE PAGES ARE ACCEPTABLE) See attached floor plan		
EXTERIOR FEATURES OF NOTE Building 107 has a screened front porch and a back porch has been enclosed and is used as a breakfast area.		
INTERIOR FEATURES OF NOTE (DESCRIBE FLOOR PLANS, IF NOT SKETCHED) See attached copy of floor plan		
MAJOR ALTERATIONS AND ADDITIONS WITH DATES NONE		
PRESENT CONDITION AND USE The building is in a deteriorated condition and is vacant at the present time.		
OTHER INFORMATION AS APPROPRIATE This residential building has been used to house employees at this medical center since construction.		
SOURCES OF INFORMATION (INCLUDING LISTING ON NATIONAL REGISTER, STATE REGISTERS, ETC.) Government records. Original architectural drawings. VAMC Biloxi, MS		
COMPILER, AFFILIATION VETERANS ADMINISTRATION	DATE 10 September 1987	

VETERANS ADMINISTRATION MEDICAL CENTER,  
 BUILDING 107  
 HABS No. MS-269-F (Page 2)


BUILDING NUMBERS  
DESCRIPTION

- 1 MEDICAL ADMINISTRATION & MCV
- 2 KITCHEN - DINING & ADMINISTRATIVE OFFICES
- 3 PSYCHIATRIC SERVICE 1, WARD B
- 4 PSYCHIATRIC SERVICE 1, WARD C
- 5 ALCOHOLIC TREATMENT WARD B
- 6 CENTRAL HEATING PLANT
- 7 MASON SHOP
- 8 ENGINEERING SHOPS & MAT
- 9 FLASHPOLE
- 10 BUILDING MANAGEMENT - LOCKER ROOM
- 11 PSYCHIATRIC SERVICE WARD F
- 12 GATEHOUSE
- 13 GARAGE (3 car)
- 14 GARAGE (4 car)
- 15 MATERIAL STORAGE
- 16 SMOKE STACK
- 17 FUEL OIL TANK
- 18 ENGINEERING STORAGE
- 19 STAFF SINGLE QUARTERS
- 20 P.M.R.S. CORR & ED THERAPY, MCV
- 21 PAVILION
- 22 GENERAL STORAGE
- 23 LAUNDRY
- 24 PSYCHIATRIC SERVICE 1, WARD G
- 25 CHAPEL
- 26 ADMINISTRATION BUILDING
- 27 SIPHON CHAMBER (woodwork)
- 28 SEDIMENTATION CHAMBER (woodwork)
- 29 THERAPEUTIC EXERCISE CLINIC BUILDING
- 30 TRANSCLOSURE
- 31 STAFF SINGLE QUARTERS (recon/land area)
- 32 BUILDING MANAGEMENT STORAGE
- 33 OCCUPATIONAL THERAPY BUILDING
- 34 WATER TANK & TOWER
- 35 SPECIAL SERVICES BUILDING
- 36 BUS STOP SHELTER
- 37 SWITCH HOUSE
- 38 COOLING TOWER
- 39 PADMOUNT TRANSFORMER
- 40 TRANSCLOSURE
- 41 REST SHELTER (recon/land area)
- 42 COOLING TOWER
- 43 EMERGENCY GENERATOR
- 44 PADMOUNT TRANSFORMER
- 45 PADMOUNT TRANSFORMER
- 46 PADMOUNT TRANSFORMER
- 47 PAVILION (recon/land area)
- 48 PAVILION (recon/land area)
- 49 BARBEQUE PIT (recon/land area)
- 50 GREENHOUSE
- 51 UNDERGROUND STORAGE TANKS
- 52 STORAGE (recon/land area)
- 53 GARAGE (1 car - 200 area)
- 54 UNDERPASS
- 55 BOILER FEED & OIL STORAGE TANKS
- 56 BUILDING MANAGEMENT (internal)
- 57 ENGINEERING SHOPS
- 58 BUILDING MANAGEMENT (exterior)
- 59 T680
- 60 T634
- 61 T640

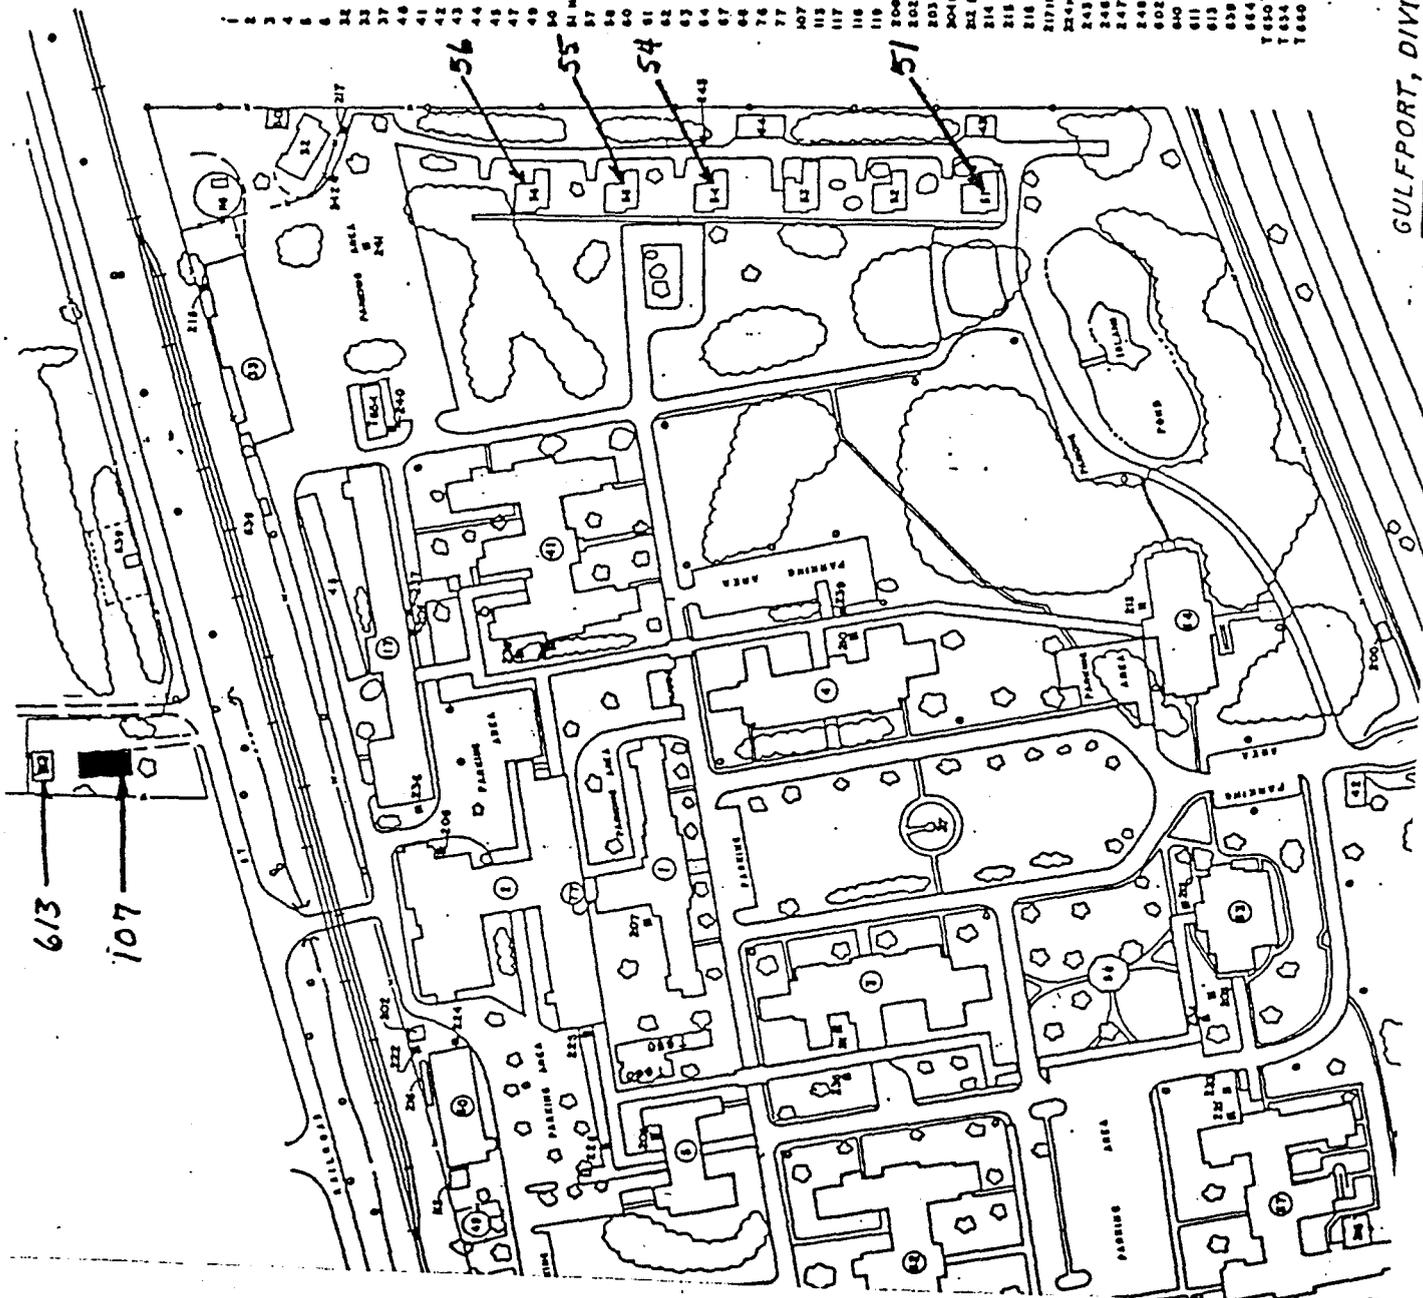

GULFPORT, DIVISION

613  
 107

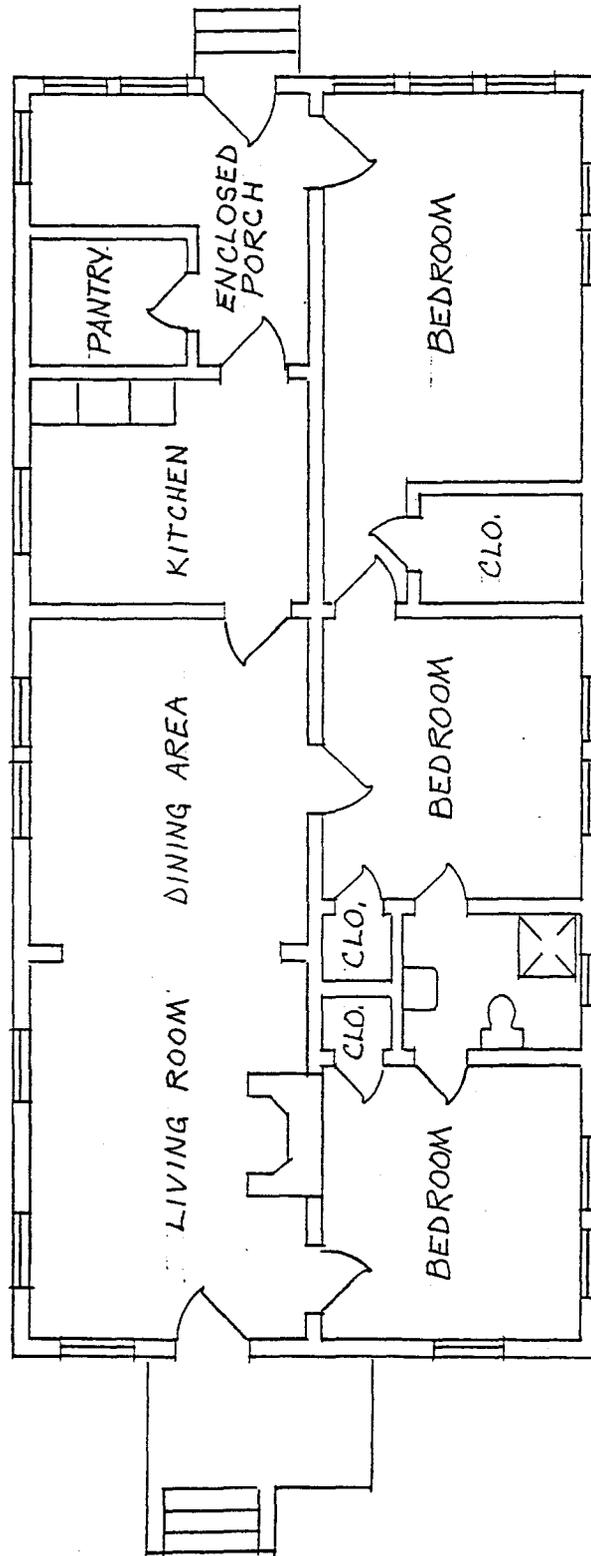

FLOOR PLAN - QUARTERS NO. 107

VA MEDICAL CENTER - GULFPORT

SCALE: 1/8" = 1'-0"