

SOLDIERS' NATIONAL HOME, HOUSE (BUILDING 202)
(Veterans Administration Medical Center)
4300 West Third Street
Dayton
Montgomery County
Ohio

HABS No. OH-2364-D

HABS
OHIO
57-DAYT,
IID-

PHOTOGRAPHS

WRITTEN HISTORICAL AND DESCRIPTIVE DATA

HISTORIC AMERICAN BUILDINGS SURVEY

National Park Service

Northeast Region

U. S. Custom House

200 Chestnut Street

Philadelphia PA 19106

HISTORIC AMERICAN BUILDINGS SURVEY
SOLDIERS' NATIONAL HOME, HOUSE (BUILDING 202)

HABS
OHIO
57-DAYT
IID-

(Veterans Administration Medical Center) HABS No. OH-2364-D

Location: 4300 West Third Street, Dayton, Montgomery County, Ohio
USGS Miamisburg Quadrangle, Universal Transverse Mercator
Coordinates: 16.735000.4403265


Significance: One of only two single residences remaining at the Soldiers' National Home, this house is an eclectic composition combining Shingle Style, Queen Anne and Tudor features, but has been altered.

Description: Facing west, this two-and-one-half-story residence features multiple front gables and a wrap-around porch with diagonal stickwork. The central entrance is emphasized by a gable in the porch roof with stick ornament resembling half-timbering. In the early 1950s, the house was covered with asbestos shingles, which are falling off the porch railing, revealing fishscale shingles. The windows vary in size and rhythm, including single, paired and tripled openings with one-over-one sash. Paired windows recessed within the front gable have diamond pane casement sash.


History: Built in 1899, this house was last occupied by the chaplain. The house was vacated when the main steam line failed during the winter of 1977-1978.

Sources: Records of the Veterans Administration Medical Center

Historian: Beth Sullebarger
Sullebarger Associates
March 10, 1994

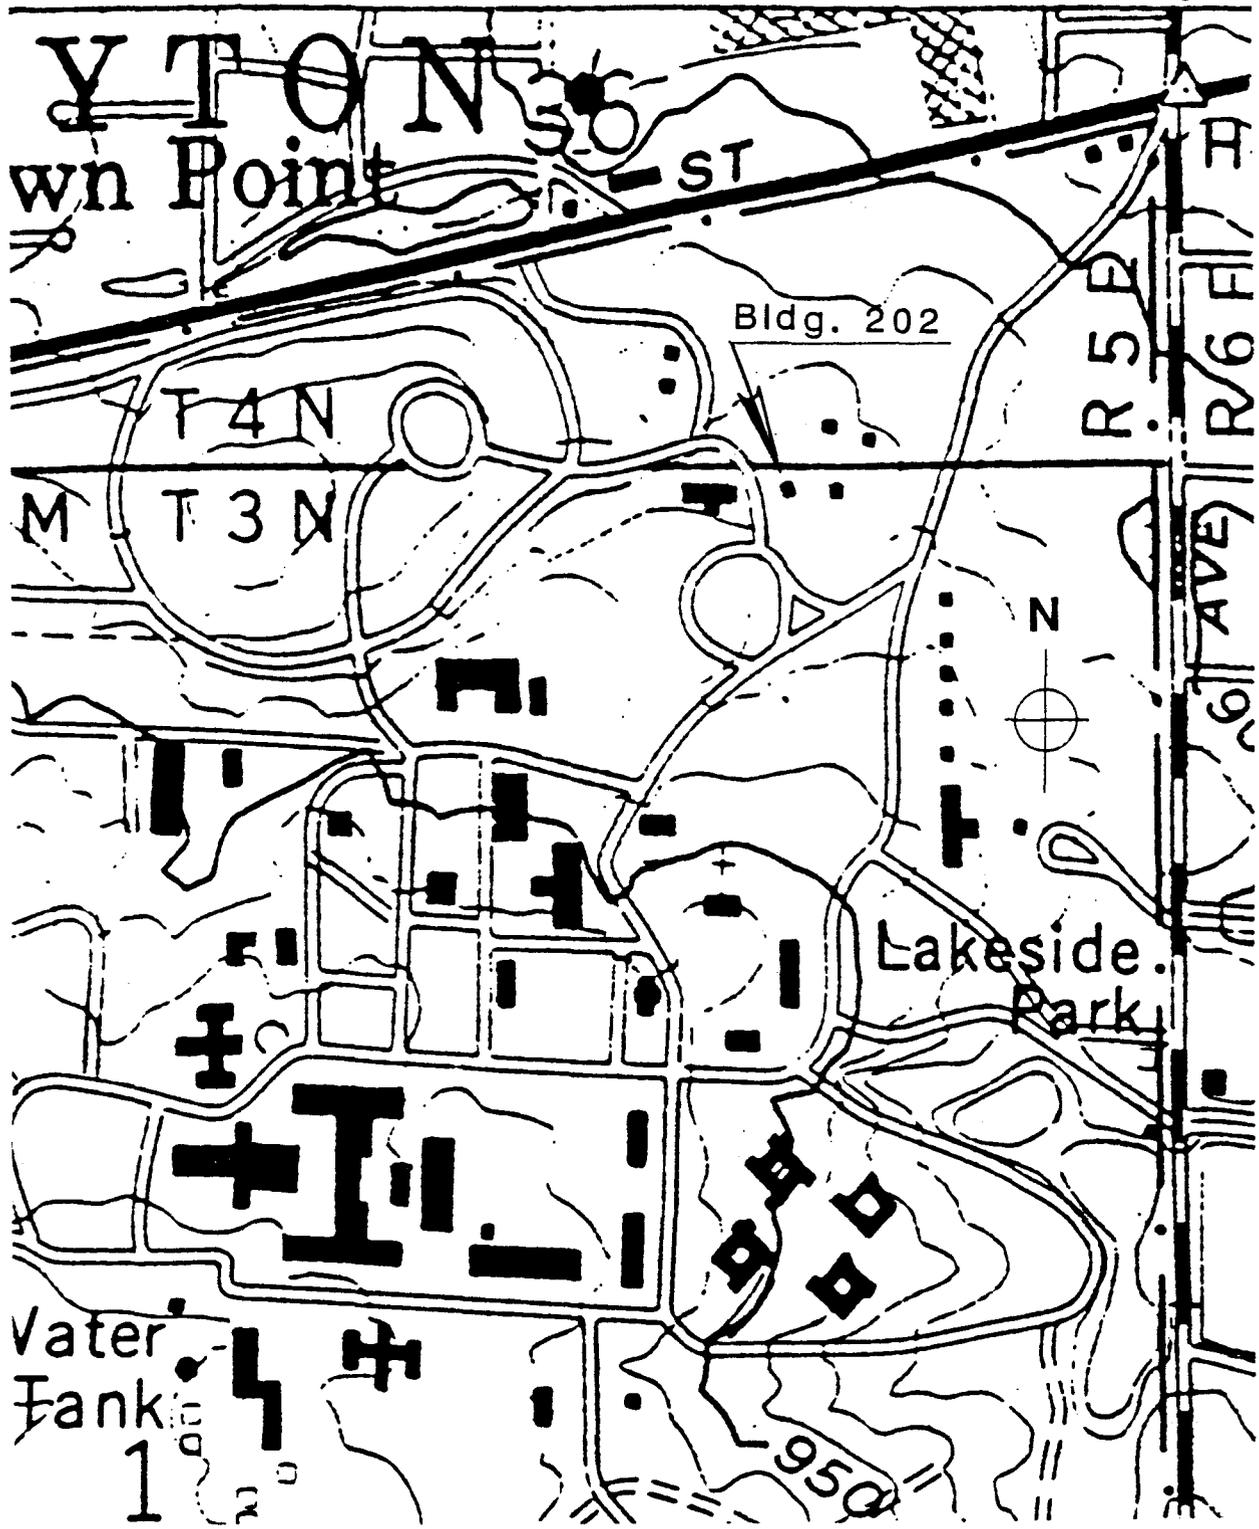

Soldiers' National Home, House (Building 202)
 (Veterans Administration Medical Center)
 HABS No. OH-2364-D
 (Page_3)

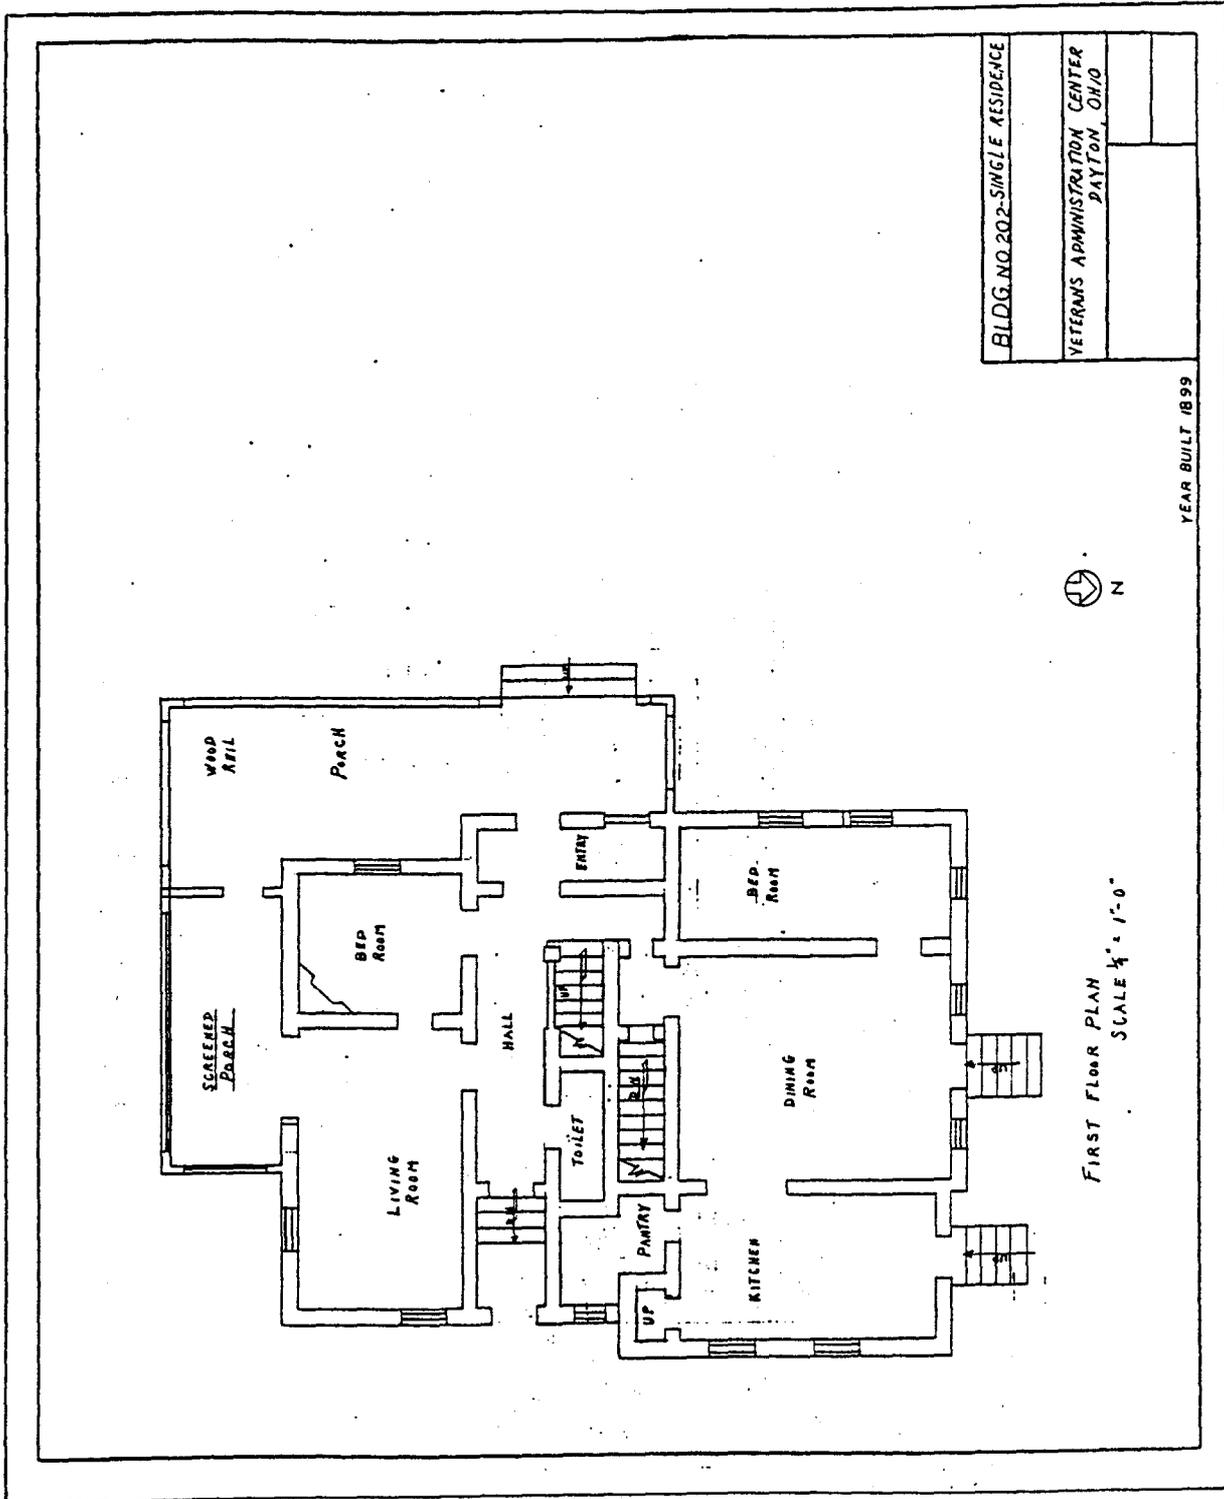

BLDG. NO. 202-SINGLE RESIDENCE
 VETERANS ADMINISTRATION CENTER
 DAYTON, OH/O

YEAR BUILT 1899



FIRST FLOOR PLAN
 SCALE 1/4" = 1'-0"

Undated First Floor Plan, Engineering Service, Veterans Administration Medical Center, Dayton, Ohio